



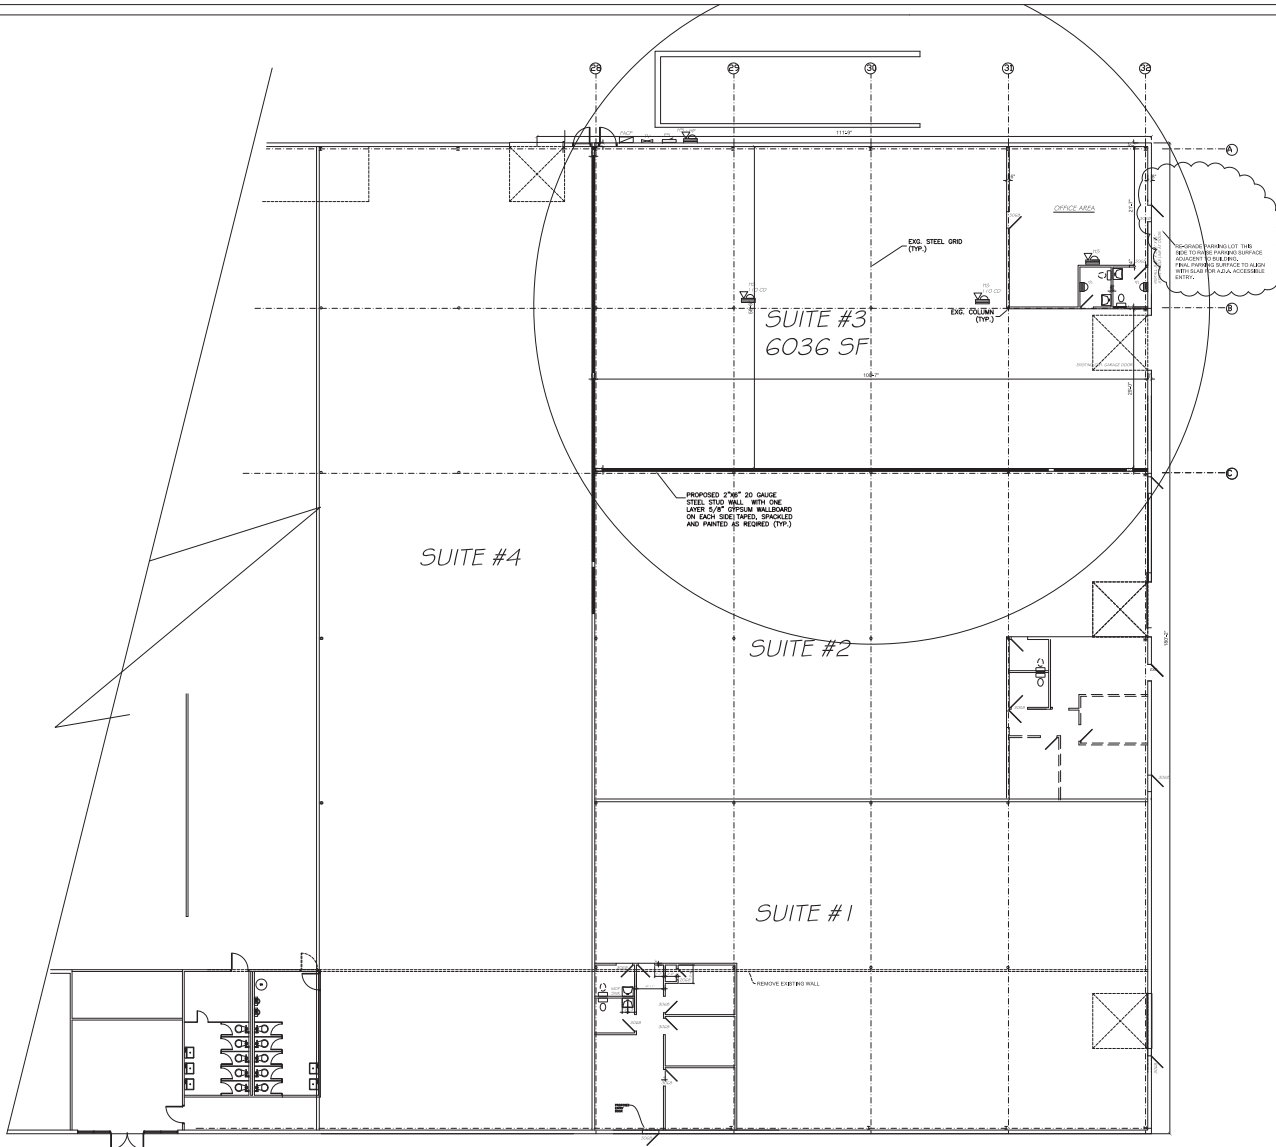

FIRE ALARM PLAN
SCALE: 3/32" = 1'-0"

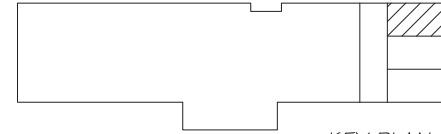

KEY PLAN
SCALE: NTS

FIRE ALARM LEGEND	
	FIRE ALARM CONTROL PANEL
	HORN (TYPICAL)
	STROBE
	MANUAL PULL STATION
	ALARM SWITCH
	FIRE EXTINGUISHER
	LOCATION TO BE DETERMINED IN FIELD

NOTE: FIRE SUPPRESSION SYSTEM TO BE DESIGNED BY OTHERS
NOTE: INSTALL FIRE ALARM SYSTEM (DESIGN BY OTHERS)

Malden Township Office
1000 N. 10th St.
Malden, NJ 07728
Phone: 732-777-1030
Fax: 732-777-1030
Attn: [Name]
Malden Township Office
1000 N. 10th St.
Malden, NJ 07728
Phone: 732-777-1030
Fax: 732-777-1030
Attn: [Name]



PROPOSED COMMERCIAL WAREHOUSE FIT-OUT FOR:
GATEWAY BUSINESS PARK
BUILDING 1, SUITE 3 LOT: 47.01 BLOCK: 49
HOWELL TOWNSHIP, MONMOUTH COUNTY, NEW JERSEY

Title: FIRE ALARM PLAN	
Project Number: B101008B	3-10-08
Drawn By: BP	3-10-08
Checked By: AZ	3-10-08
Date: 9-10-08	3-10-08