


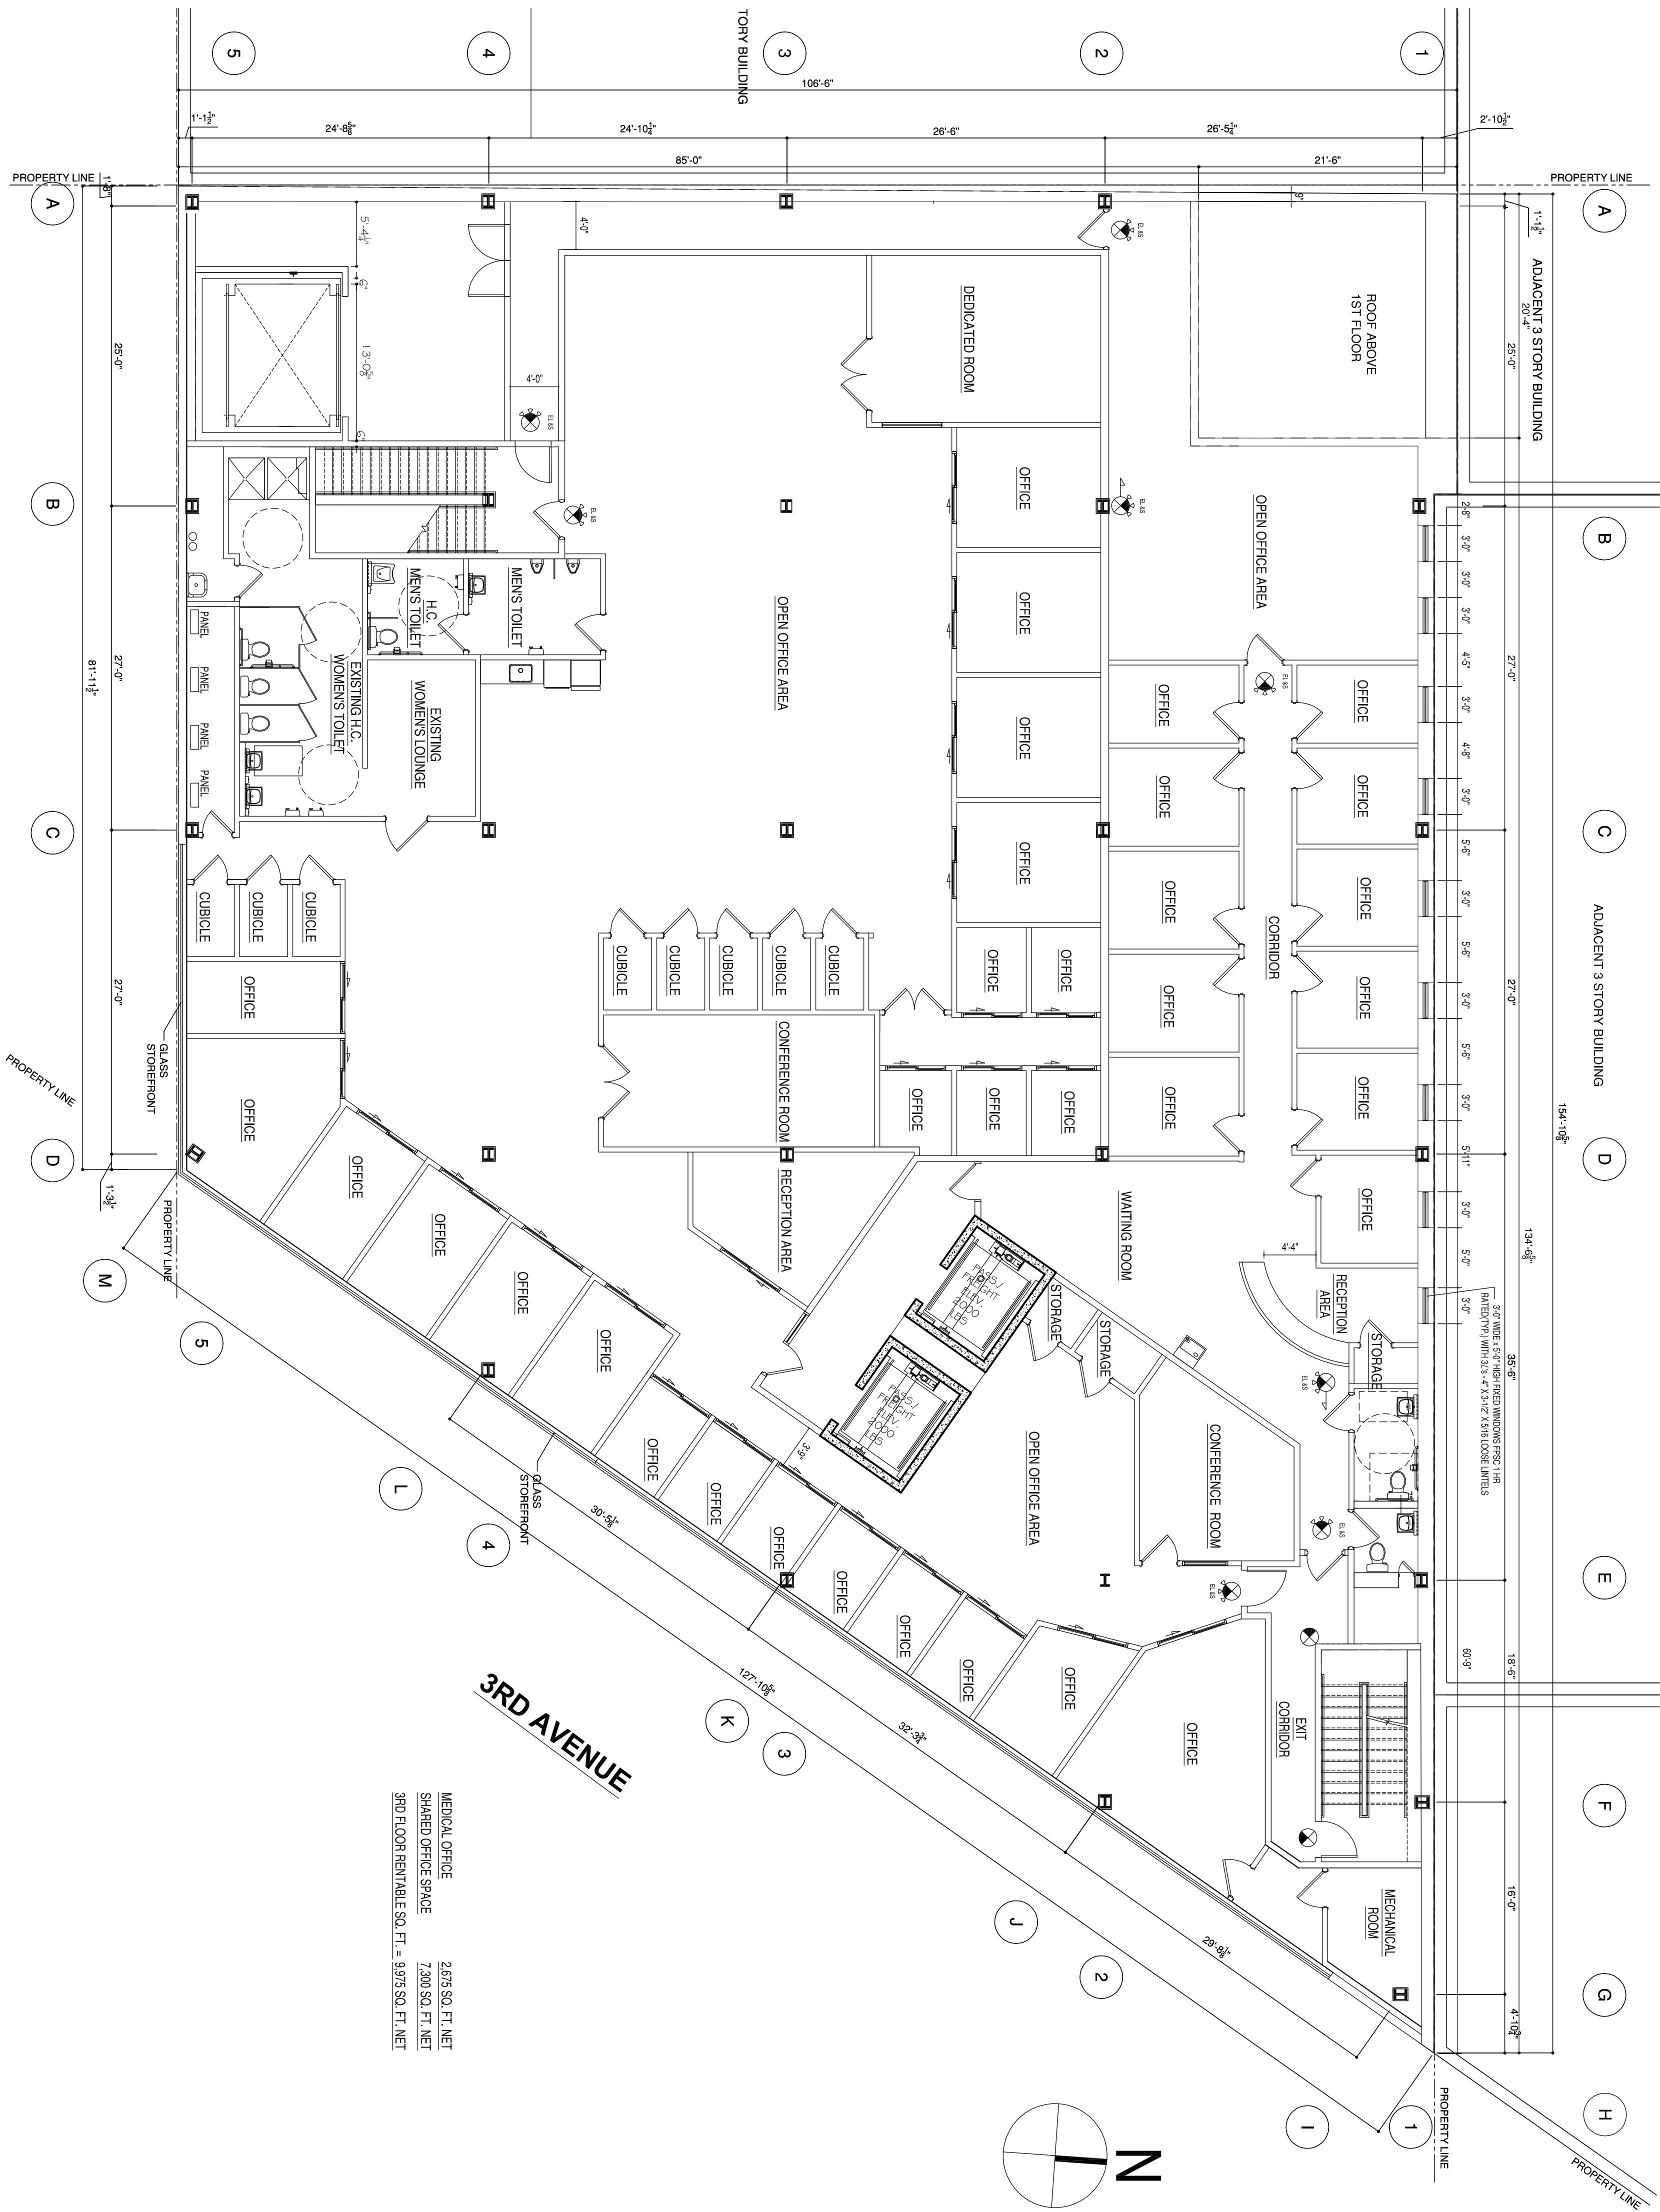

148TH STREET
THIRD FLOOR PLAN
SCALE: 1/8" = 1'-0"

EMERGENCY LIGHTING LEGEND

- E = EXISTING, N = NEW, D = DEMOLISH, R = RELOCATED
- 2 HEAD EMERGENCY EXIT SIGN & LIGHT (8" HIGH LETTERS COMBO. UNIT (LITHONIA LIGHTING LH0MSMR 120V)
- 2 LIGHT EMERGENCY BATTERY PACK LIGHT 120V (LITHONIA LIGHTING ELM2) SURFACE / WALL MOUNTED
- DIRECTIONAL EXIT SIGN
- EMERGENCY EXIT SIGN W/ BATTERY PACK LIGHT 120V (LITHONIA LIGHTING ELM2)
- DIRECT WIRE PHOTOELECTRIC SMOKE ALARM W/ STROBE (GENTEX CORP. Md# 7109CS-W)

PLAN UPDATED TO SHOW AS BUILT CONDITIONS FOR BUILDING DEPARTMENT USE
PLAN UPDATED TO SHOW AS BUILT CONDITIONS FOR BUILDING DEPARTMENT USE



BY

SD

niego associates

architects / planners

600 Hempstead Turnpike, West Hempstead, New York, 11552
TEL.: 516 - 486 - 5340 FAX: 516 - 486 - 4903 EMAIL: SOLNIEGO@AOL.COM

NO	DATE	REVISIONS
1	09/30/2018	
2	07/25/2018	

ELIDEX
2823 THIRD AVENUE
BRONX, N.Y.
THIRD FLOOR PLAN

SCALE: 1/8" = 1'-0"

DATE: 07/11/2016

JOB #: 16-25

DRAWN BY: K.P.

CHECKED BY:

DWG. NO.

A 300 02

DATE: 07/11/2016

JOB #: 16-25

DRAWN BY: K.P.

CHECKED BY:

DWG. NO.

A 300 02