

SEAL

PROGRESS SET

PROJECT TITLE

THIRD FLOOR
TENANT FIT-UP
ZONE 5

MONROE STREET LOFTS
25 MONROE STREET
ALBANY, NY

SHEET TITLE

THIRD FLOOR
POWER & DATA
PLAN

OWNER/ CONSULTANT

DRAWN BY

NP

CHECKED BY

SKT

DATE

04.10.07

PROJECT NO.

06-023A

REVISIONS




3tarchitects.com

418 BROADWAY-ALBANY, NY-12207
PH 518 618 0900 FX 518 618 0901

SHEET NO.

A2.5

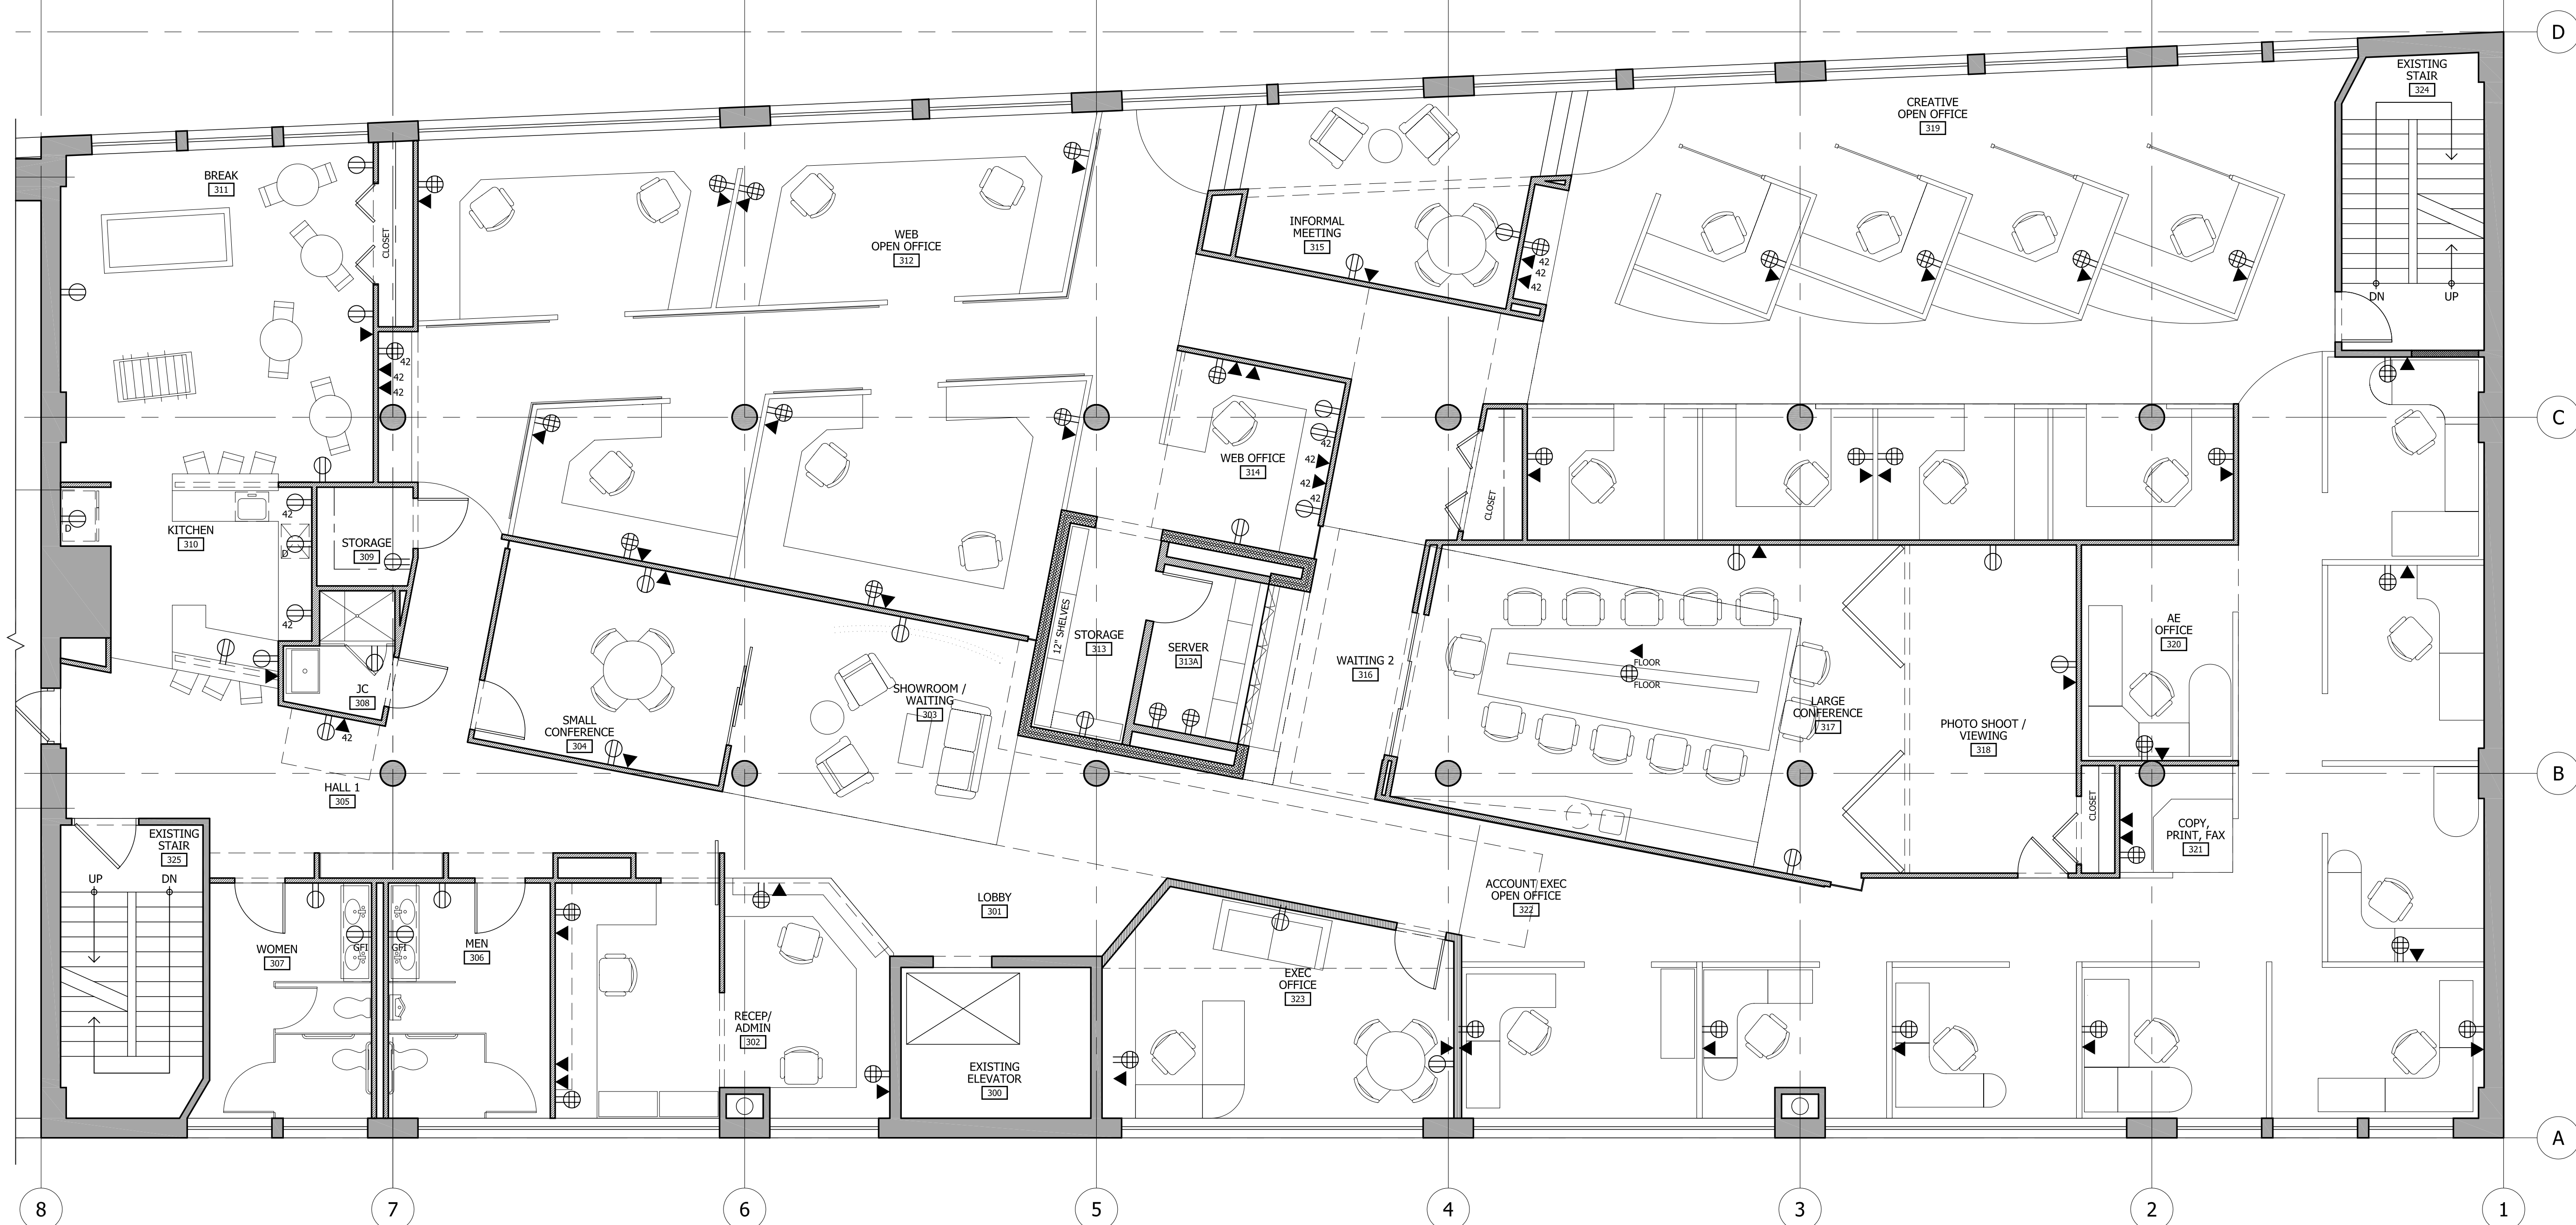

1 THIRD FLOOR POWER & DATA PLAN
SCALE: 3/16" = 1'-0"



LEGEND:

- ⊕ QUAD RECEPTACLE. VERIFY RECEPTACLE AND COVER PLATE COLOR W/ ARCHITECT.
- ⊖ GFI GFI RECEPTACLE. VERIFY RECEPTACLE AND COVER PLATE COLOR W/ ARCHITECT.
- ⊖ DEDICATED RECEPTACLE. COORDINATE W/ EQUIPMENT MANUFACTURERS' REQ'S. VERIFY RECEPTACLE AND COVER PLATE COLOR W/ ARCHITECT.
- ◀ DUPLEX DATA RECEPTACLE. VERIFY RECEPTACLE AND COVER PLATE COLOR WITH ARCHITECT.